

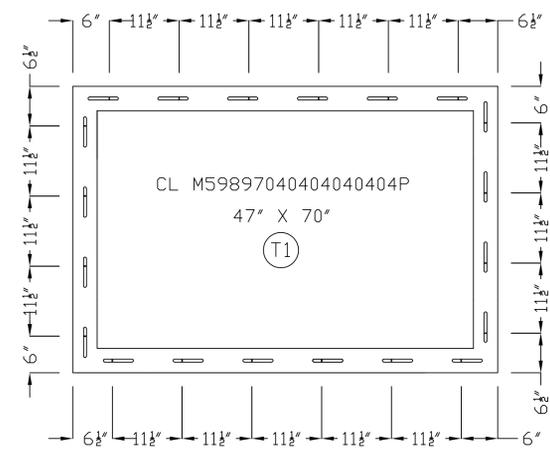




FREEZER

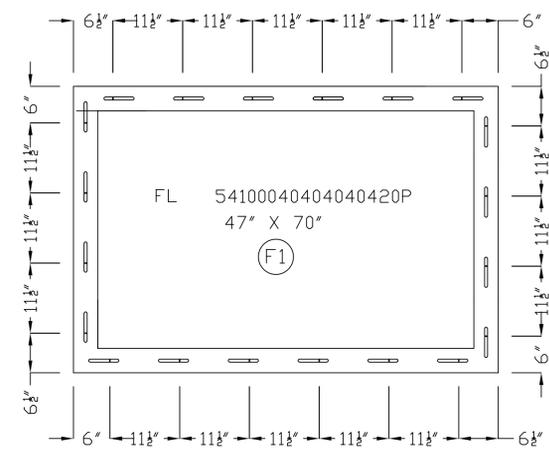

OPTION A DOOR SWING

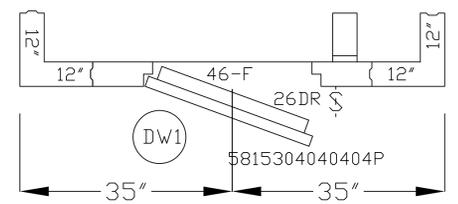


OPTION B DOOR SWING

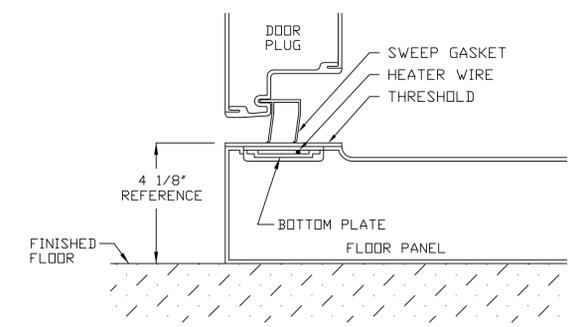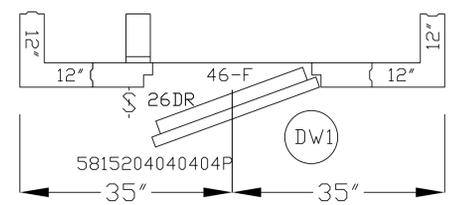

STANDARD WITH FLOOR FREEZER
DETAIL 02

ORDER# _____

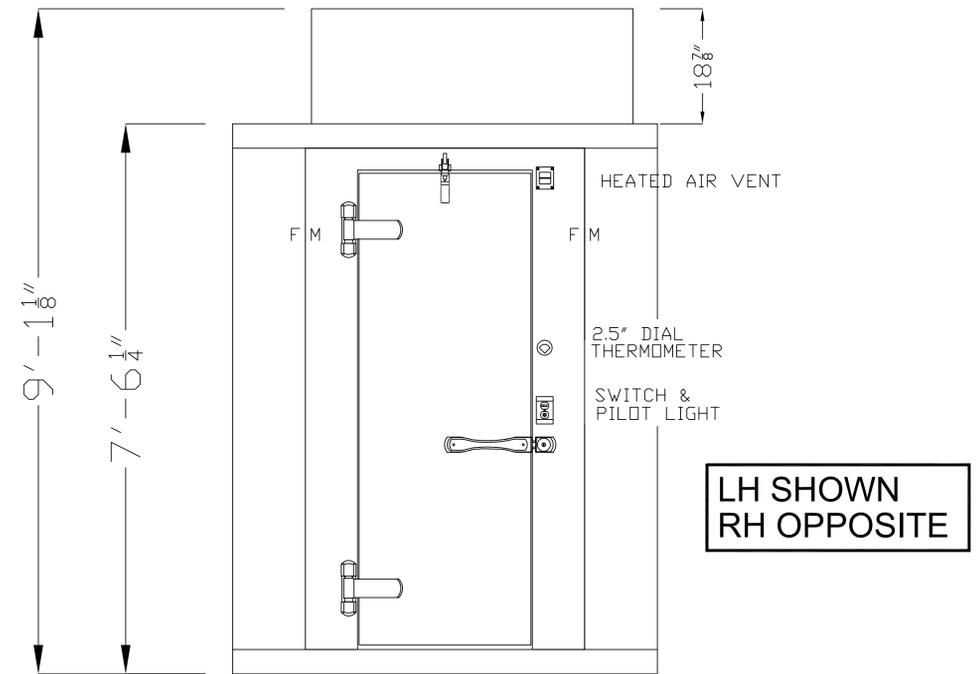

DOOR ELEVATION
46x82.25DS 26x78DR P-P-FZR STD
THRESHOLD DETAIL 02

WALK-IN SPECIFICATIONS

SIZE: 5'-10" X 3'-11" X 7'-6 1/4"

PANELS:

ALL FOAMED PANELS ARE 4"

EXTERIOR FINISH:

EXTERIOR FINISH: 26GA STUCCO GALVALUME

INTERIOR FINISH:

WALLS: 26GA STUCCO GALVALUME
CEILINGS: 26GA STUCCO GALVALUME

FLOOR TYPE:

FREEZER - .100 SMOOTH ALUMINUM

HEIGHT:

OD 7'-6 1/4" ID 6'-10 5/8"

DOORS:

46x82.25DS 26x78 DR STD FZR
115-60-1/1.0 AMPS

ACCESSORIES:

(NONE)

REFRIG.

PF094T3 208/230/60-1 R404A 10.6 AMPS

USE this drawing for installation



IMPORTANT NOTES:

- 1) ALLOW MINIMUM 1" CLEARANCE ALL AROUND WALK-IN.
- 2) WALK-IN CEILING IS NOT DESIGNED FOR FOOT TRAFFIC OR STORAGE.
- 3) GENERAL CONTRACTOR TO REFER TO DESIGN AND SPECIFICATIONS MANUAL FOR FLOOR DETAIL INFORMATION.
- 4) SPECIAL NOTE TO GENERAL CONTRACTOR AND SUBCONTRACTOR FOR QUARRY TILE OR CONCRETE WEARING FLOOR - THE SHEET METAL PANEL FACINGS MAY BE SUSCEPTABLE TO STAINING DUE TO EXCESSIVE MOISTURE CREATED BY THE HYDRATION OF CONCRETE TYPE MATERIALS. THEREFORE, IT IS ABSOLUTELY NECESSARY THAT EACH ROOM BE PROPERLY VENTILATED. ALSO NOTE THAT SPECIAL PRECAUTIONS MUST BE TAKEN WHEN USING MURIC ACID DUE TO EFFECTS HYDROCHLORIC ACID FUMES HAVE ON ALUMINUM AND STAINLESS STEEL MATERIALS.

SCALE:	3/8"=1'-0"
DRAWING NO.:	QS7-064-F-T
DRAWN BY:	DDC
DATE:	06/18/15
DEALER:	PROJECT: 5'-10" X 3'-11" X 7'-6 1/4"
2915 TENNESSEE AVENUE NORTH P.O. BOX 550 PARSONS, TN. 38363 (901) 847-6361	
KOLPAK WALK-INS	